


Drawing name: H:\47873000\CADD\CONSTR\CONSTR CONT AND CRATE\C20-C25-UTILITY-3000.dwg C20 Nov 05, 2008 1:01pm by: britt.stephens
 This document, together with the concepts and designs presented herein, is intended only for the specific purpose and client for which it was prepared. Reuse of and improper reliance on this document without written authorization and adaptation by Kimley-Horn and Associates, Inc. shall be without liability to Kimley-Horn and Associates, Inc.

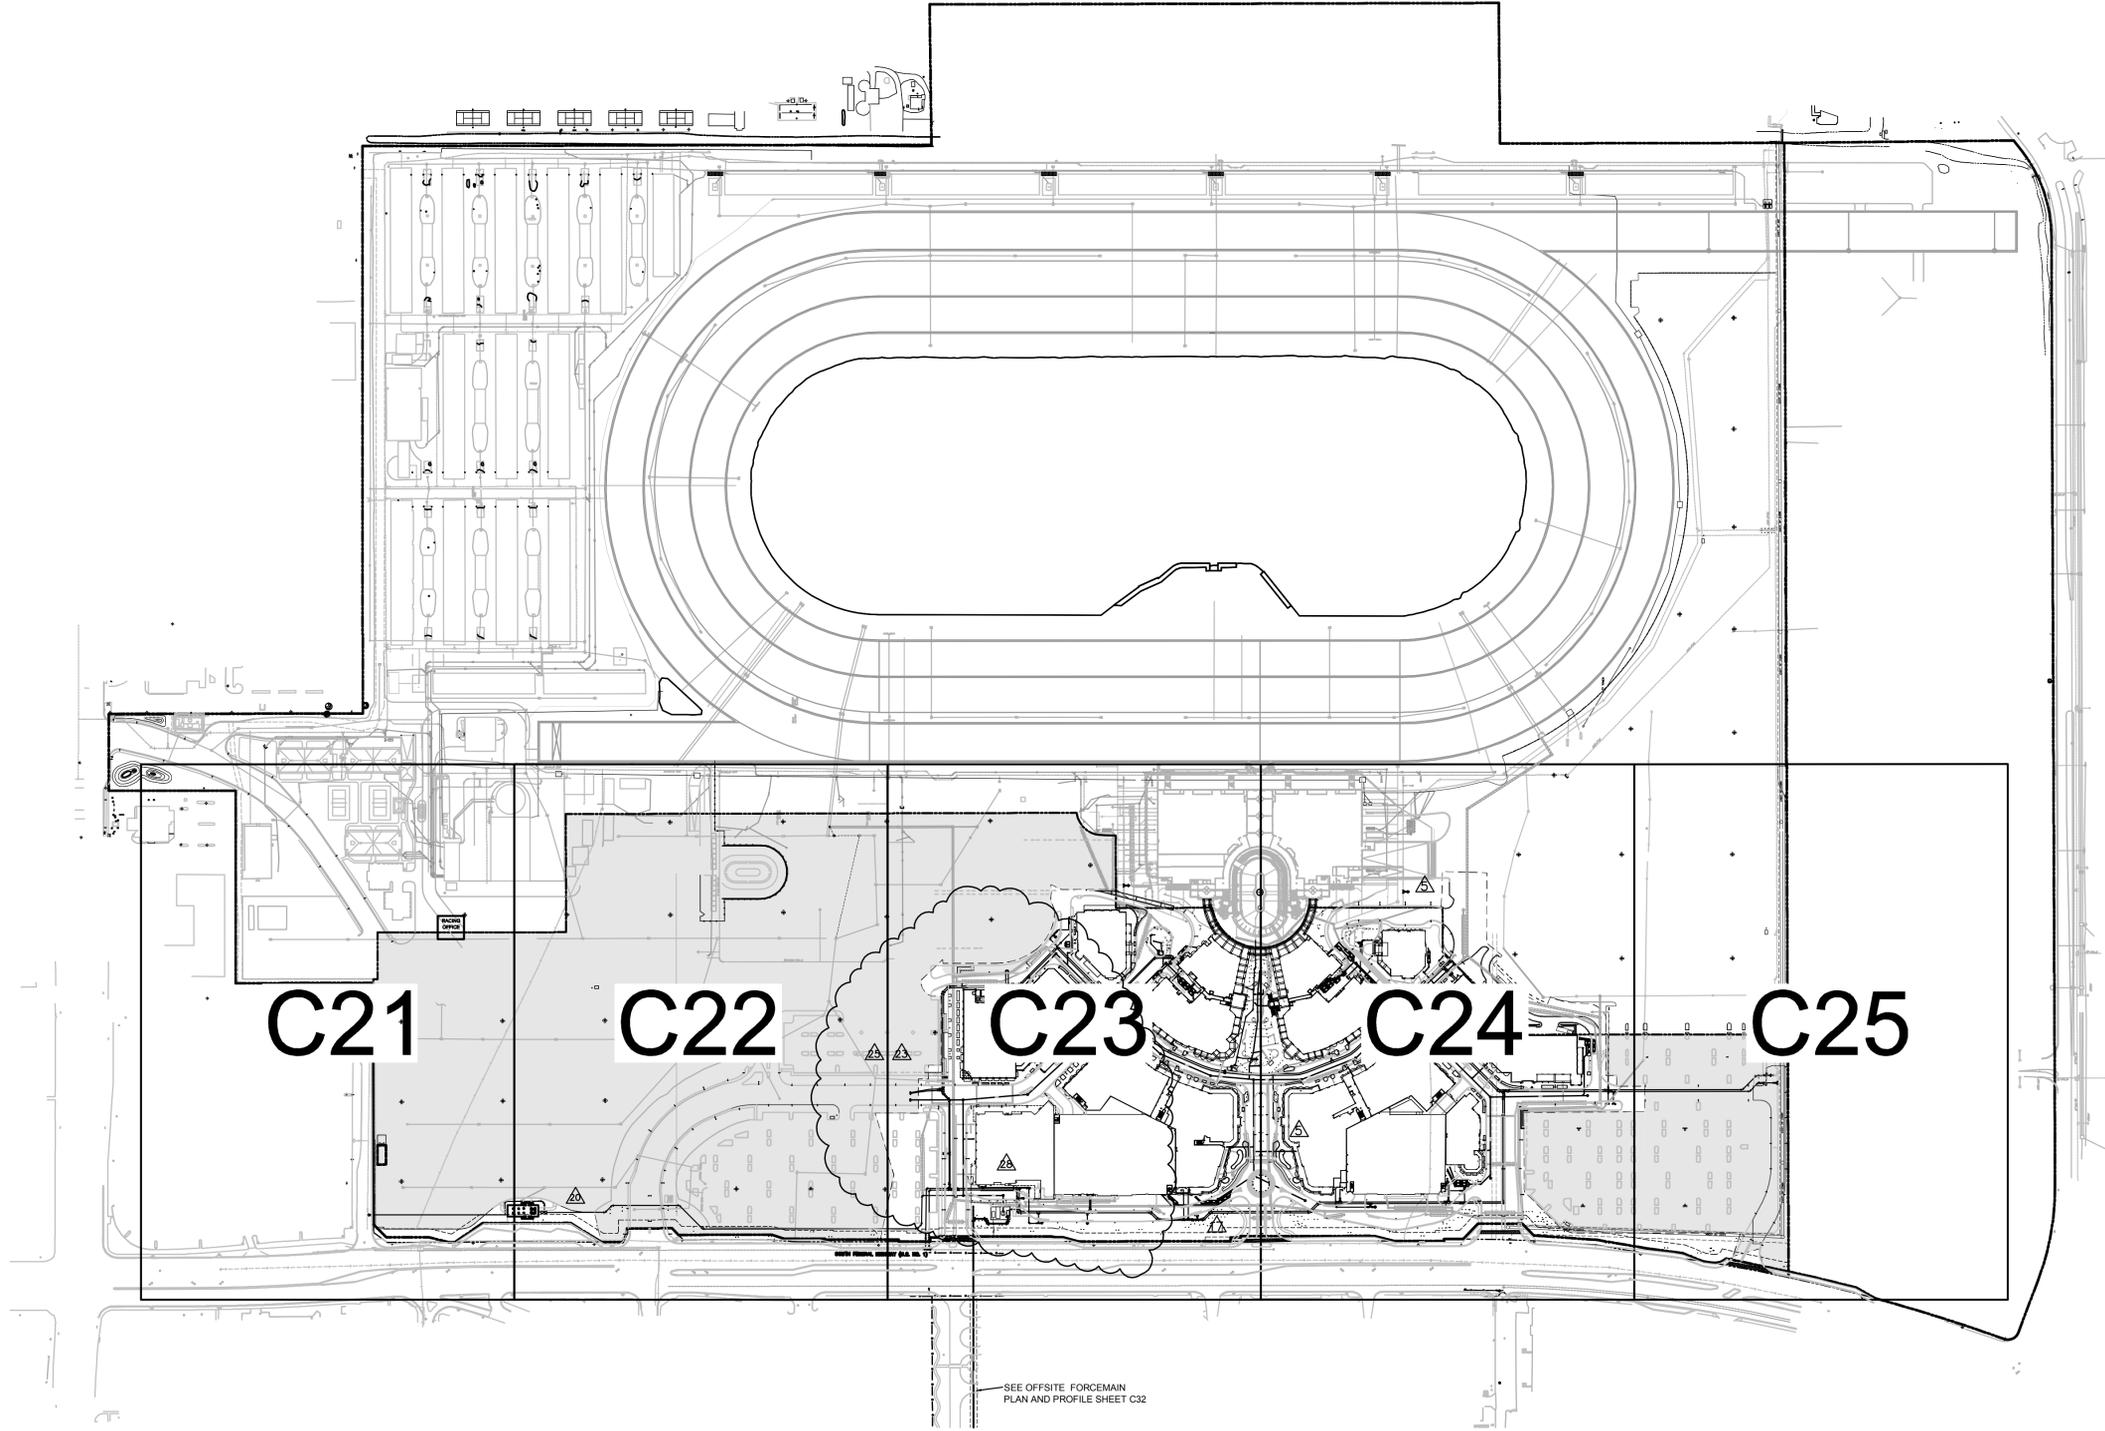

- NOTE:**
1. PROPOSED DRY UTILITIES ARE NOT SHOWN ON THE PLANS AT THIS TIME.
 2. SEE SANITARY PLAN AND PROFILES, SHEETS C29 THROUGH C31 FOR SANITARY DETAILS.
 3. SEE SHEET C43 FOR COVER AND PIPES MATERIAL REQUIREMENTS FOR CROSSING.
 4. SEE SHEET C43 FOR UTILITY SEPARATION NOTES.
 5. CONTRACTOR SHALL SUBMIT A DETAILED MAINTENANCE OF TRAFFIC PLAN TO FLORIDA DEPARTMENT OF TRANSPORTATION FOR THEIR APPROVAL FOUR WEEKS PRIOR TO COMMENCEMENT OF CONSTRUCTION. MAINTENANCE OF TRAFFIC SHALL BE IN ACCORDANCE WITH CURRENT FLORIDA D.O.T. STANDARDS, ESPECIALLY 600 SERIES INDEX OF THE DESIGN STANDARDS AND THE MANUAL OF UNIFORM TRAFFIC CONTROL DEVICES.
 6. CONTRACTOR TO INSTALL IRRIGATION SLEEVING CONCURRENT WITH OTHER UNDERGROUND UTILITY INSTALLATION. PLEASE REFER TO THE LANDSCAPE AND IRRIGATION PLANS FOR IRRIGATION SLEEVING REQUIREMENTS AND LOCATIONS.
 7. CONTRACTOR TO VERIFY SIZE, MATERIAL, DEPTH, AND LOCATION OF EXISTING UTILITIES PRIOR TO ORDERING CONNECTION MATERIALS.


LEGEND

NO GRADING TO OCCUR IN THIS AREA (WITHIN LAC BOUNDARY)

PAD ELEVATION TO BE 8" BELOW FINISHED FLOOR ELEVATION

SEE ROADWAY IMPROVEMENT PLANS FOR ROADWAY IMPROVEMENTS IN FDOT RIGHT OF WAY.

SEE OFFSITE FORCEMAIN PLAN AND PROFILE SHEET C32

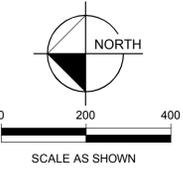

DATE 5/31/06		PROJECT NO. 047873000		SHEET NUMBER C20	
VILLAGE AT GULFSTREAM PARK PHASE 1		BROWARD COUNTY		FLORIDA	
SCALE AS NOTED		DESIGN ENGINEER: ROSCOE L. BIBY, P.E.		DESIGN NO. 85	
DESIGNED BY: MST		FLORIDA REGISTRATION NUMBER: 34789		BULLETIN No. 81	
DRAWN BY: SWM		CHECKED BY: RLB		BULLETIN No. 60	
SEAL		KIMLEY-HORN AND ASSOCIATES, INC.		BULLETIN No. 44	
		601 21st Street, Suite 300, Vero Beach, FL 32960		BULLETIN No. 31	
		Phone: (772) 562-7981 Fax: (772) 562-9889		BULLETIN No. 3	
		WWW.KIMLEY-HORN.COM CA 0000696		BULLETIN No. 85	
				9/29/08 ESM	
				7/17/08 ELS	
				4/21/08 ESM	
				1/25/08 ELS	
				10/25/07 ELS	
				4/6/07 ESM	
				DATE	
				BY	